



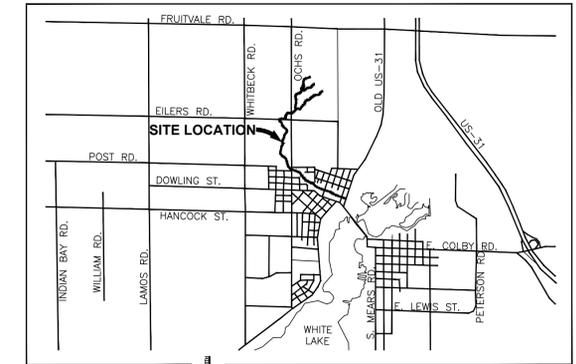

# MONTAGUE DRAIN

CITY OF MONTAGUE & MONTAGUE TOWNSHIP, MUSKEGON COUNTY, MI

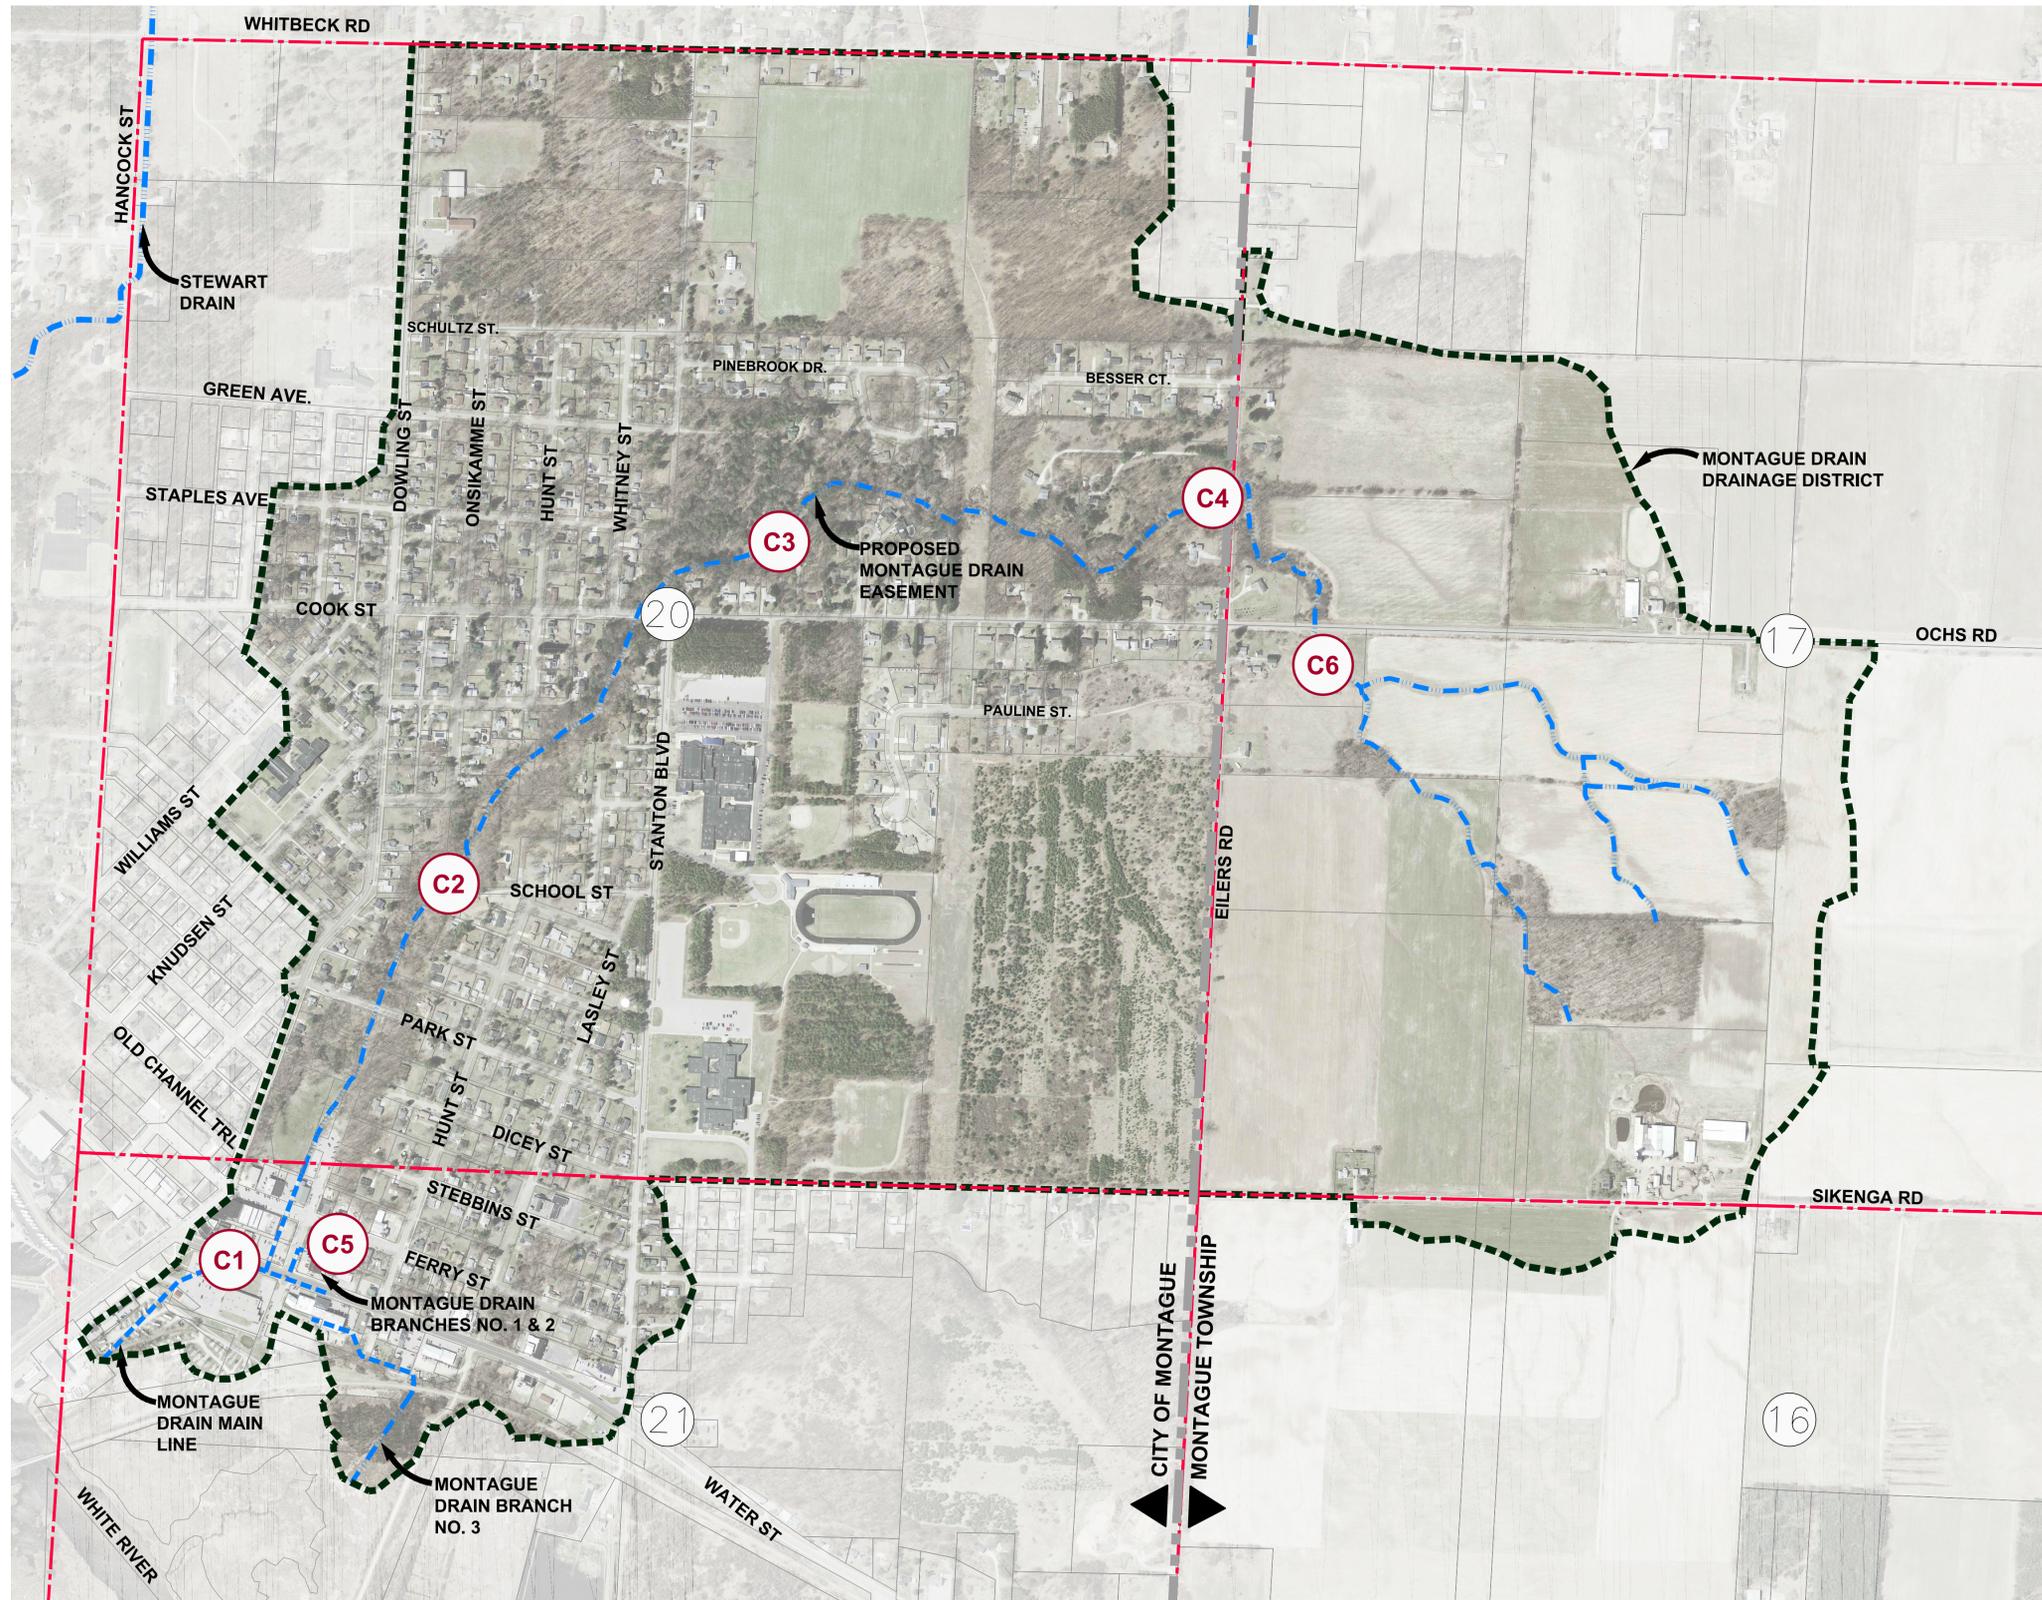

## INDEX OF SHEETS

- CS - COVER SHEET**
- C1 - PLAN AND PROFILE**  
(STA: 0+00 - 22+50)
- C2 - PLAN AND PROFILE**  
(STA: 22+50 - 46+50)
- C3 - PLAN AND PROFILE**  
(STA: 46+50 - 77+50)
- C4 - PLAN AND PROFILE**  
(STA: 77+50 - 109+00)
- C5 - PLAN AND PROFILE**  
(STA: 0+00 - 5+00) BRANCH 1  
(STA: 0+00 - 3+00) BRANCH 2
- C6 - DETENTION BASIN**
- C7 - CROSS SECTIONS**

## UTILITY CONTACTS

**GAS - DTE ENERGY**  
VINCENT DUCA  
(231) 777-4034 (O)  
(231) 578-0488 (C)  
DUCAV@DTEENERGY.COM


**WATER & SANITARY - CITY OF MONTAGUE DPW**  
SCOTT BEISHUZEN  
(231) 893-2235 (O)  
(231) 740-0306 (C)  
DPW@CITYOFMONTAGUE.ORG

**ELECTRIC - CONSUMERS ENERGY**  
MICHELE ANDREE  
(231) 332-2621 (O)  
(231) 332-2602 (F)  
MICHELE.ANDREE@CMSENERGY.COM

**TELEPHONE - FRONTIER COMMUNICATIONS**  
CINDY WHITEMAN  
(231) 727-1134 (O)  
(231) 727-1116 (F)  
CINDY.WHITEMAN@FTR.COM

## LEGEND

- OPEN CHANNEL DRAIN
- ENCLOSED DRAIN
- DRAINAGE DISTRICT BOUNDARY
- SECTION LINE
- PROPERTY LINES
- SECTION NUMBERS
- SHEET NUMBERS

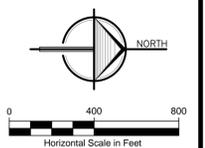

**3 WORKING DAYS  
BEFORE YOU DIG  
CALL MISS DIG®  
1-800-482-7171**

ALL UTILITIES AS SHOWN ARE APPROXIMATE LOCATIONS DERIVED FROM ACTUAL MEASUREMENTS AND AVAILABLE RECORDS. THEY SHOULD NOT BE INTERPRETED TO BE EXACT LOCATION NOR SHOULD IT BE ASSUMED THAT THEY ARE THE ONLY UTILITIES IN THE AREA.

3800 W. River Dr. Ste. A  
Comstock Park MI 49321  
ph. 616.301.7888  
fax. 616.784.0757  
www.LRE.com



REVISIONS:	NO.	ISSUED FOR:	DATE
	1.	PRELIMINARY REVIEW	11/2017
	2.	OWNER REVIEW - 50% DESIGN	02/2018
	3.	OWNER REVIEW - 75% DESIGN	08/2018


MUSKEGON COUNTY DRAIN COMMISSION  
MUSKEGON, MICHIGAN

MONTAGUE DRAIN  
CITY OF MONTAGUE & MONTAGUE TOWNSHIP, MUSKEGON COUNTY, MICHIGAN




PROJECT NUMBER:	DATE
174012.01	11/2017
SURVEYED BY: RLB, CVF	11/2017
DESIGNED BY: CRM	11/2017
DRAFTED BY: RAG, LGG, NDJ	2/2018
LDACC, DVF	

COVER SHEET


SHEET NUMBER  
**CS**

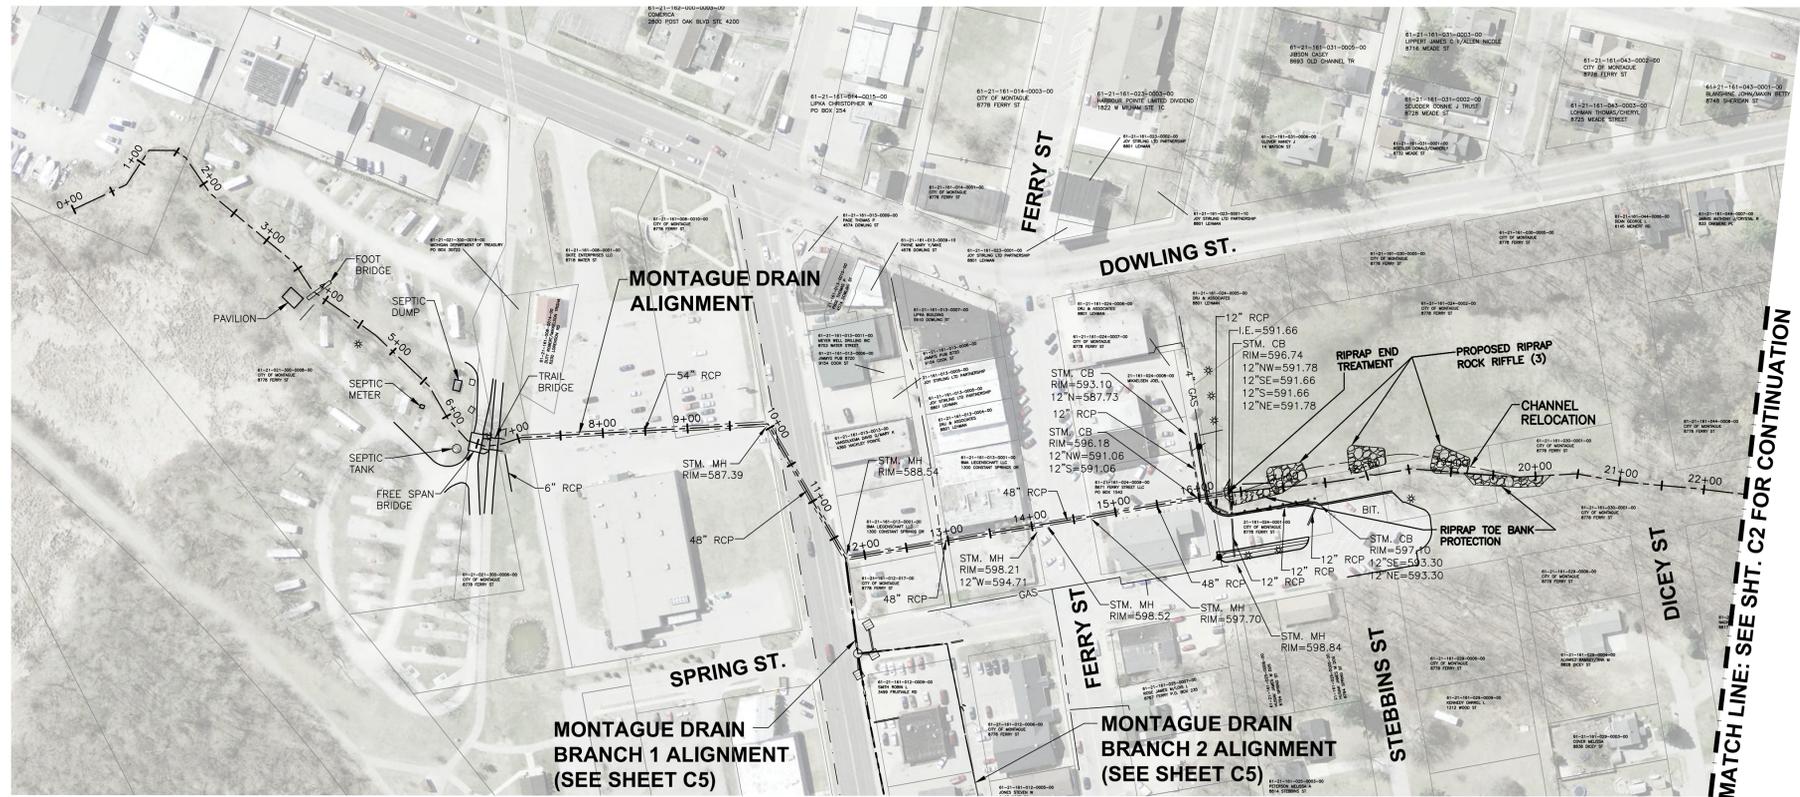

MATCH LINE: SEE SHT. C2 FOR CONTINUATION

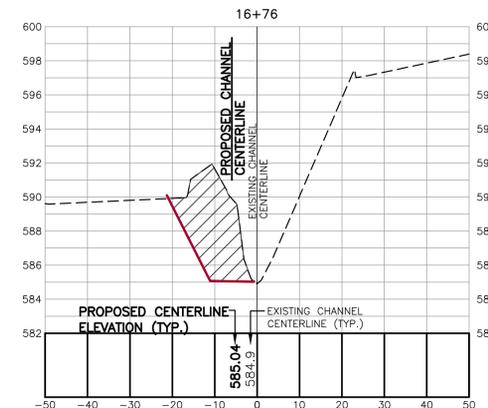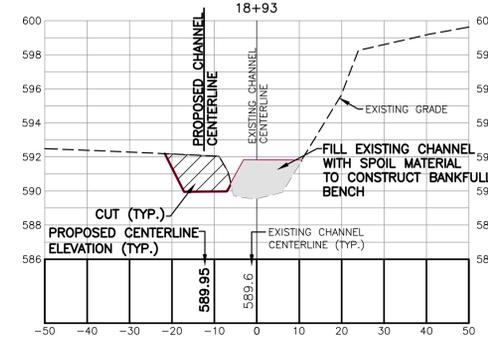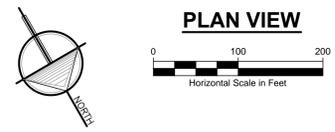

**CROSS SECTIONS**  
SCALE: HORIZONTAL: 1" = 20'  
VERTICAL: 1" = 5'

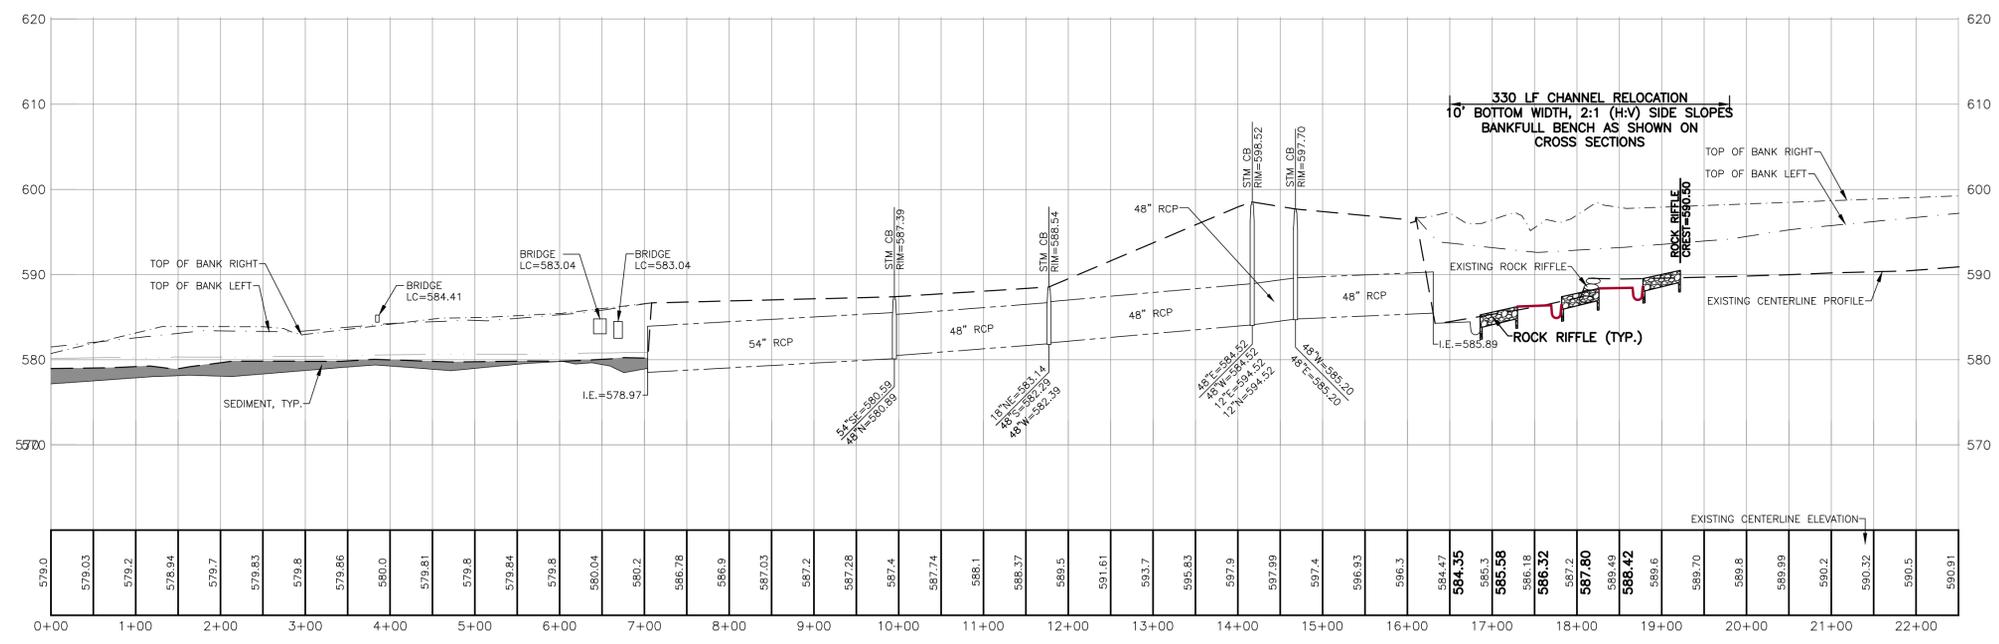

**CENTERLINE PROFILE**  
SCALE: HORIZONTAL: 1" = 100'  
VERTICAL: 1" = 10'

PRELIMINARY



**3 WORKING DAYS BEFORE YOU DIG CALL MISS DIG**  
1-800-482-7171

ALL UTILITIES AS SHOWN ARE APPROXIMATE LOCATIONS DERIVED FROM ACTUAL MEASUREMENTS AND AVAILABLE RECORDS. THEY SHOULD NOT BE INTERPRETED TO BE EXACT LOCATION NOR SHOULD IT BE ASSUMED THAT THEY ARE THE ONLY UTILITIES IN THE AREA.

3800 W. River Dr. Ste. A  
Comstock Park MI 49321  
ph. 616.301.7888  
fax. 616.784.0737  
www.LRE.com

LRE

ENGINEERS & SURVEYORS

NO.	DATE
1.	11/2017
2.	02/2018
3.	08/2018

ISSUED FOR	REVISION
PRELIMINARY REVIEW	11/2017
OWNER REVIEW - 50% DESIGN	02/2018
OWNER REVIEW - 75% DESIGN	08/2018

MUSKEGON COUNTY DRAIN COMMISSION  
MUSKEGON, MICHIGAN

MONTAGUE DRAIN  
CITY OF MONTAGUE & MONTAGUE TOWNSHIP, MUSKEGON COUNTY, MICHIGAN


PROJECT NUMBER	DATE
17-07-001	11/2017

SURVEYED BY	DESIGNED BY	DRAFTED BY
RLE, CVF	CRM	RAG, LGS, NDI

PROJECT NUMBER	DATE
17-07-001	11/2017
17-07-001	11/2017
17-07-001	11/2017


PLAN & PROFILE  
STA: 0+00 - 22+50

C1

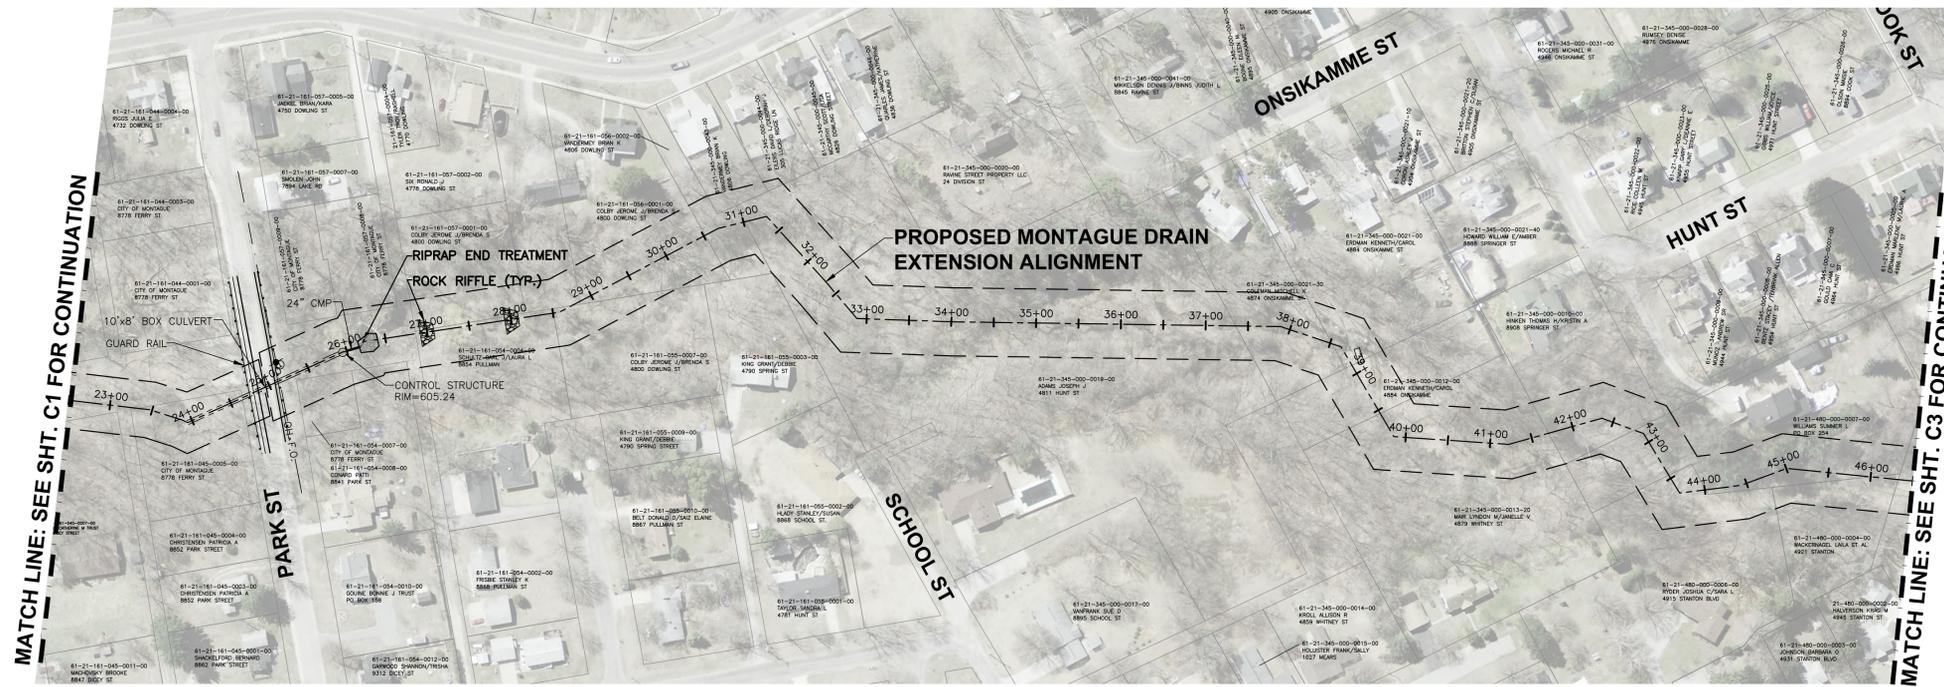

MATCH LINE: SEE SHT. C1 FOR CONTINUATION

MATCH LINE: SEE SHT. C3 FOR CONTINUATION

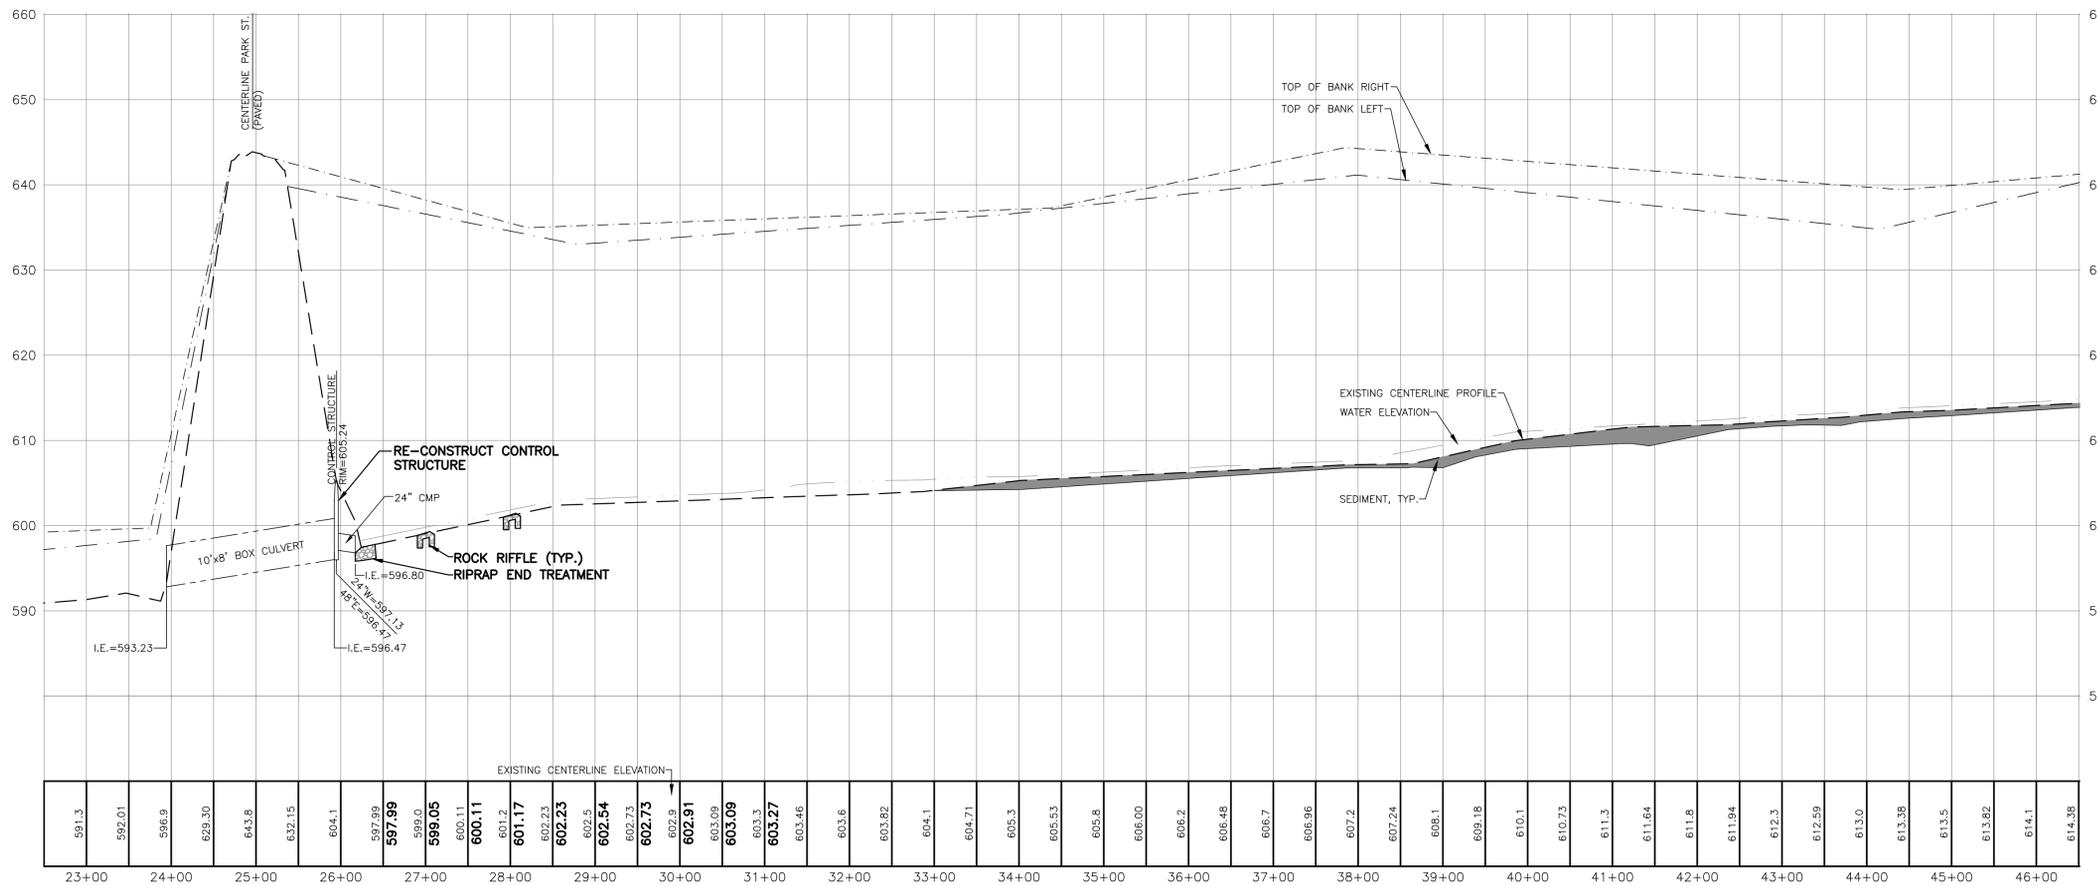

**CENTERLINE PROFILE**  
SCALE: HORIZONTAL: 1" = 100'  
VERTICAL: 1" = 10'



3 WORKING DAYS  
**BEFORE YOU DIG**  
CALL MISS DIG  
1-800-482-7171

ALL UTILITIES AS SHOWN ARE APPROXIMATE LOCATIONS DERIVED FROM ACTUAL MEASUREMENTS AND AVAILABLE RECORDS. THEY SHOULD NOT BE INTERPRETED TO BE EXACT LOCATION NOR SHOULD IT BE ASSUMED THAT THEY ARE THE ONLY UTILITIES IN THE AREA.

3800 W. River Dr. Ste. A  
Commerce Park MI 48321  
ph. 616.301.7888  
fax. 616.784.0737  
www.LREin.com




REVISIONS:	NO.	ISSUED FOR:	DATE
	1.	PRELIMINARY REVIEW	11/2017
	2.	OWNER REVIEW - 50% DESIGN	02/2018
	3.	OWNER REVIEW - 75% DESIGN	08/2018

CLIENT: MUSKEGON COUNTY DRAIN COMMISSION  
MUSKEGON, MICHIGAN  
PROJECT: MONTAGUE DRAIN  
CITY OF MONTAGUE & MONTAGUE TOWNSHIP, MUSKEGON COUNTY, MICHIGAN

PROJECT NUMBER:	DATE
17-07-01	11/2017
	11/2017
	2/2018

DESIGNED BY: RLB, CVF  
DRAFTED BY: RAG, LGS, NDI  
CAGC/DVF

 SHEET NAME: PLAN & PROFILE  
STA: 22+50 - 46+50  
SHEET NUMBER: C2

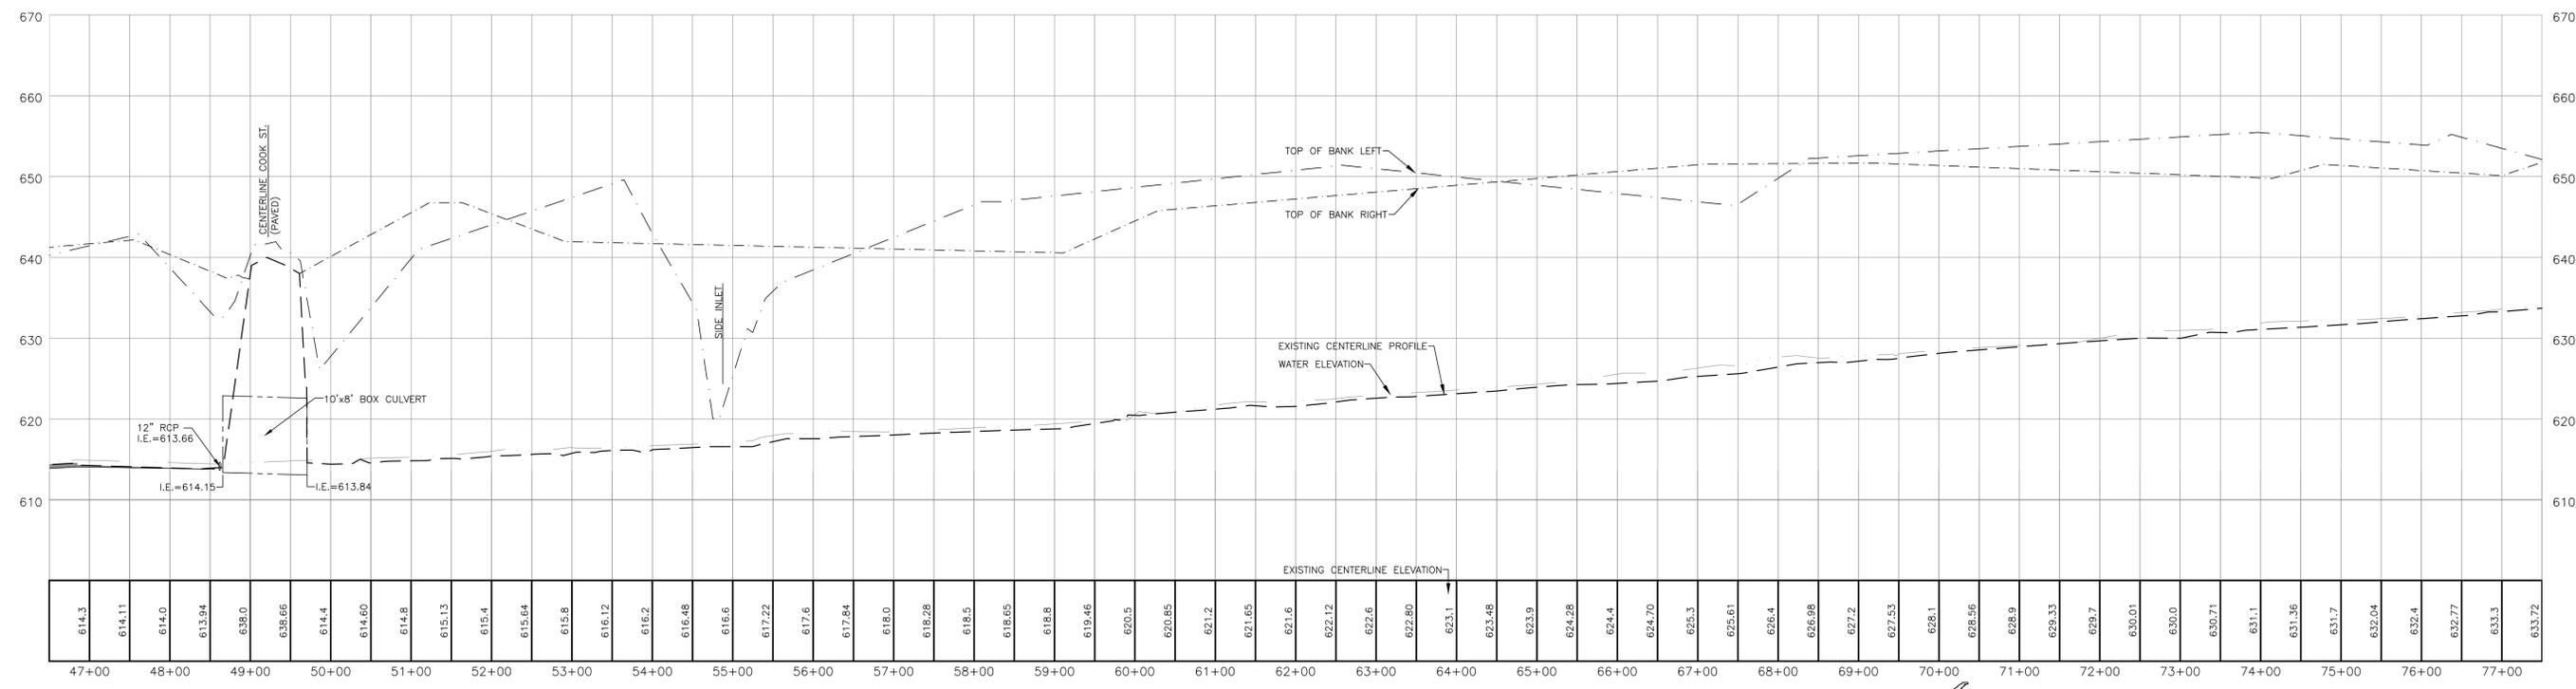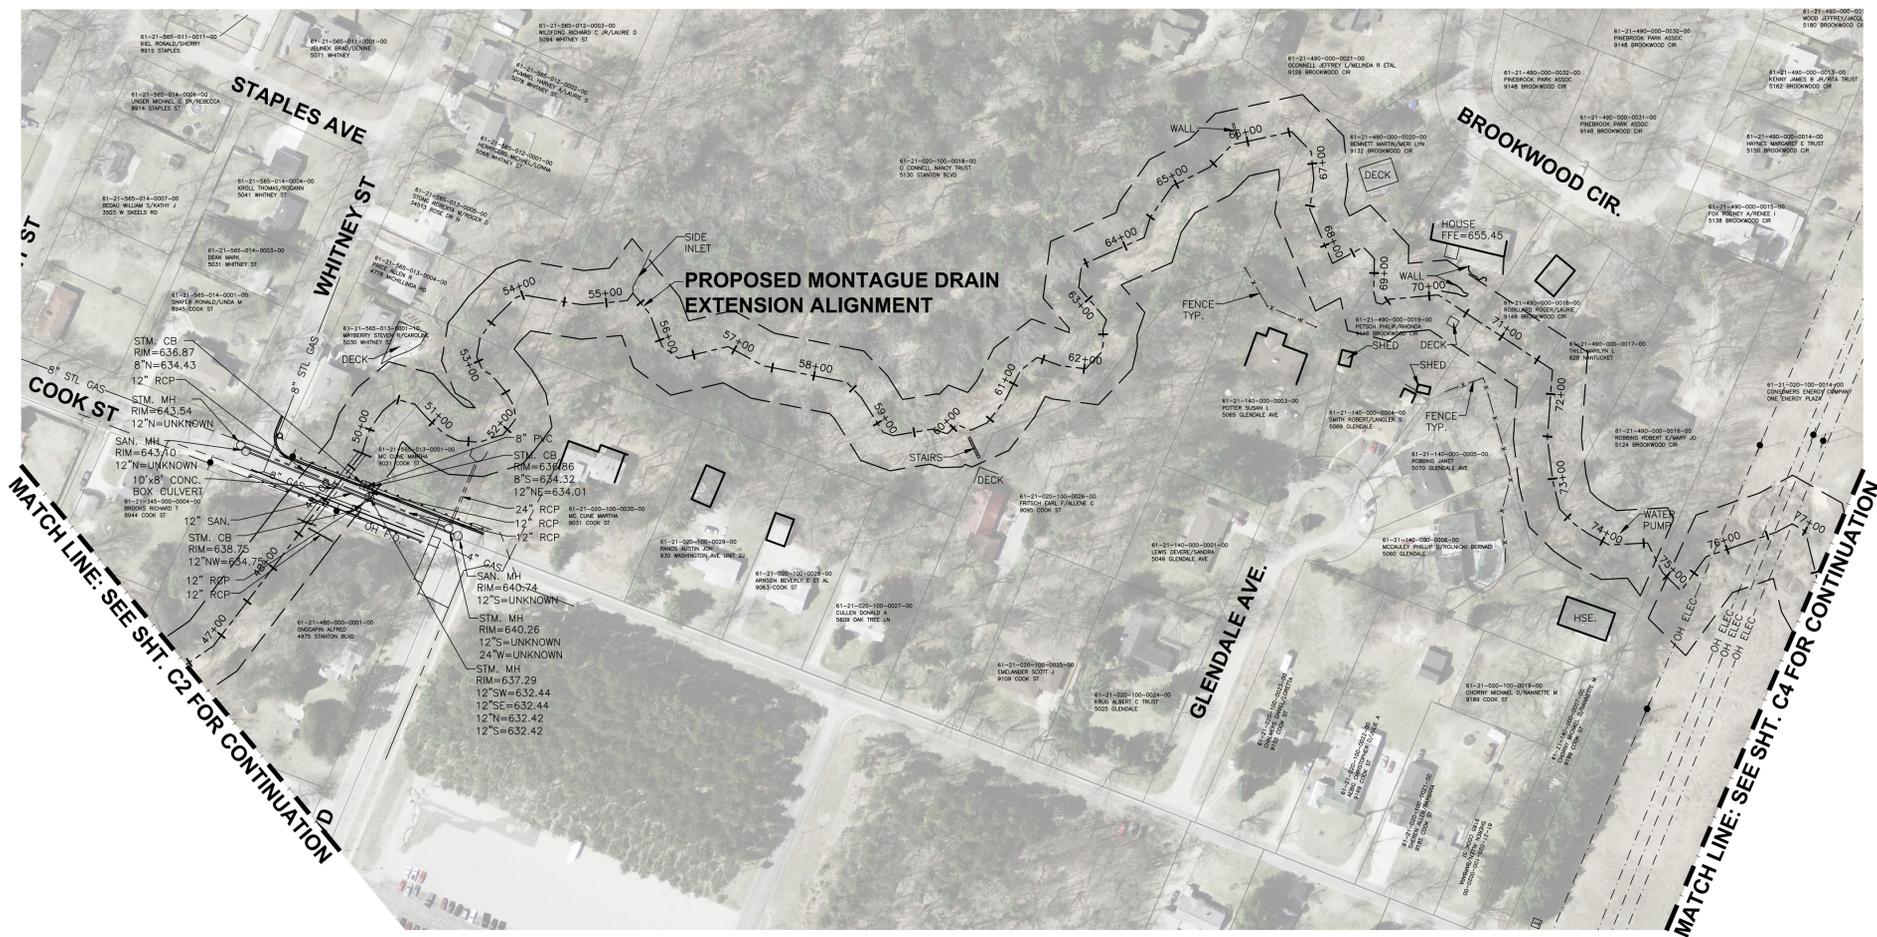

**CENTERLINE PROFILE**  
 SCALE: HORIZONTAL: 1" = 100'  
 VERTICAL: 1" = 10'

**3 WORKING DAYS  
 BEFORE YOU DIG  
 CALL MISS DIG  
 1-800-482-7171**

ALL UTILITIES AS SHOWN ARE APPROXIMATE LOCATIONS DERIVED FROM ACTUAL MEASUREMENTS AND AVAILABLE RECORDS. THEY SHOULD NOT BE INTERPRETED TO BE EXACT LOCATION NOR SHOULD IT BE ASSUMED THAT THEY ARE THE ONLY UTILITIES IN THE AREA.

3800 W. River Dr. Ste. A  
 Comstock Park MI 49321  
 Ph. 616.301.7888  
 Fax. 616.304.0757  
 www.LRE.com

**LRE**  
 ENGINEERS & SURVEYORS

NO.	ISSUED FOR	DATE
1.	PRELIMINARY REVIEW - 50% DESIGN	11/2017
2.	OWNER REVIEW - 50% DESIGN	02/2018
3.	OWNER REVIEW - 75% DESIGN	08/2018

PROJECT NUMBER	DATE
17402.01	11/2017
17402.01	11/2017
17402.01	2/2018

MUSKEGON COUNTY DRAIN COMMISSION  
 MUSKEGON, MICHIGAN

CITY OF MONTAGUE & MONTAGUE TOWNSHIP, MUSKEGON COUNTY, MICHIGAN

PROJECT: MONTAGUE DRAIN

CLIENT: MUSKEGON COUNTY DRAIN COMMISSION  
 MUSKEGON, MICHIGAN

PROJECT NUMBER: 17402.01

DATE: 11/2017

SURVEYED BY: RLB, CVF

DESIGNED BY: CRM

DRAFTED BY: RAG, LGG, NDJ

DATE: 11/2017

DATE: 2/2018

DRAWN BY: LQCC, DVF

PROJECT: MONTAGUE DRAIN

CLIENT: MUSKEGON COUNTY DRAIN COMMISSION  
 MUSKEGON, MICHIGAN

PROJECT NUMBER: 17402.01

DATE: 11/2017

SURVEYED BY: RLB, CVF

DESIGNED BY: CRM

DRAFTED BY: RAG, LGG, NDJ

DATE: 11/2017

DATE: 2/2018

DRAWN BY: LQCC, DVF

PROJECT: MONTAGUE DRAIN

CLIENT: MUSKEGON COUNTY DRAIN COMMISSION  
 MUSKEGON, MICHIGAN

PROJECT NUMBER: 17402.01

DATE: 11/2017

SURVEYED BY: RLB, CVF

DESIGNED BY: CRM

DRAFTED BY: RAG, LGG, NDJ

DATE: 11/2017

DATE: 2/2018

DRAWN BY: LQCC, DVF

PROJECT: MONTAGUE DRAIN

CLIENT: MUSKEGON COUNTY DRAIN COMMISSION  
 MUSKEGON, MICHIGAN

PROJECT NUMBER: 17402.01

DATE: 11/2017

SURVEYED BY: RLB, CVF

DESIGNED BY: CRM

DRAFTED BY: RAG, LGG, NDJ

DATE: 11/2017

DATE: 2/2018

DRAWN BY: LQCC, DVF

PROJECT: MONTAGUE DRAIN

CLIENT: MUSKEGON COUNTY DRAIN COMMISSION  
 MUSKEGON, MICHIGAN

PROJECT NUMBER: 17402.01

DATE: 11/2017

SURVEYED BY: RLB, CVF

DESIGNED BY: CRM

DRAFTED BY: RAG, LGG, NDJ

DATE: 11/2017

DATE: 2/2018

DRAWN BY: LQCC, DVF

PROJECT: MONTAGUE DRAIN

CLIENT: MUSKEGON COUNTY DRAIN COMMISSION  
 MUSKEGON, MICHIGAN

PLAN & PROFILE  
 STA:46+50 - 77+50

C3



REVISIONS:	NO.	ISSUED FOR:	DATE
	1.	PRELIMINARY REVIEW	11/2017
	2.	OWNER REVIEW - 50% DESIGN	02/2018
	3.	OWNER REVIEW - 75% DESIGN	08/2018

MUSKEGON COUNTY DRAIN COMMISSION  
 MUSKEGON, MICHIGAN  
 MONTAGUE DRAIN  
 CITY OF MONTAGUE & MONTAGUE TOWNSHIP, MUSKEGON COUNTY, MICHIGAN

PROJECT NUMBER:	DATE
17-012.01	11/2017
SURVEYED BY: RLB, CVF	11/2017
DESIGNED BY: CRM	11/2017
DRAFTED BY: RAG, LGG, RDJ	2/2018
LDCC, DVF	

PLAN & PROFILE  
 STA: 77+50 - 109+00




SHEET NUMBER  
**C4**

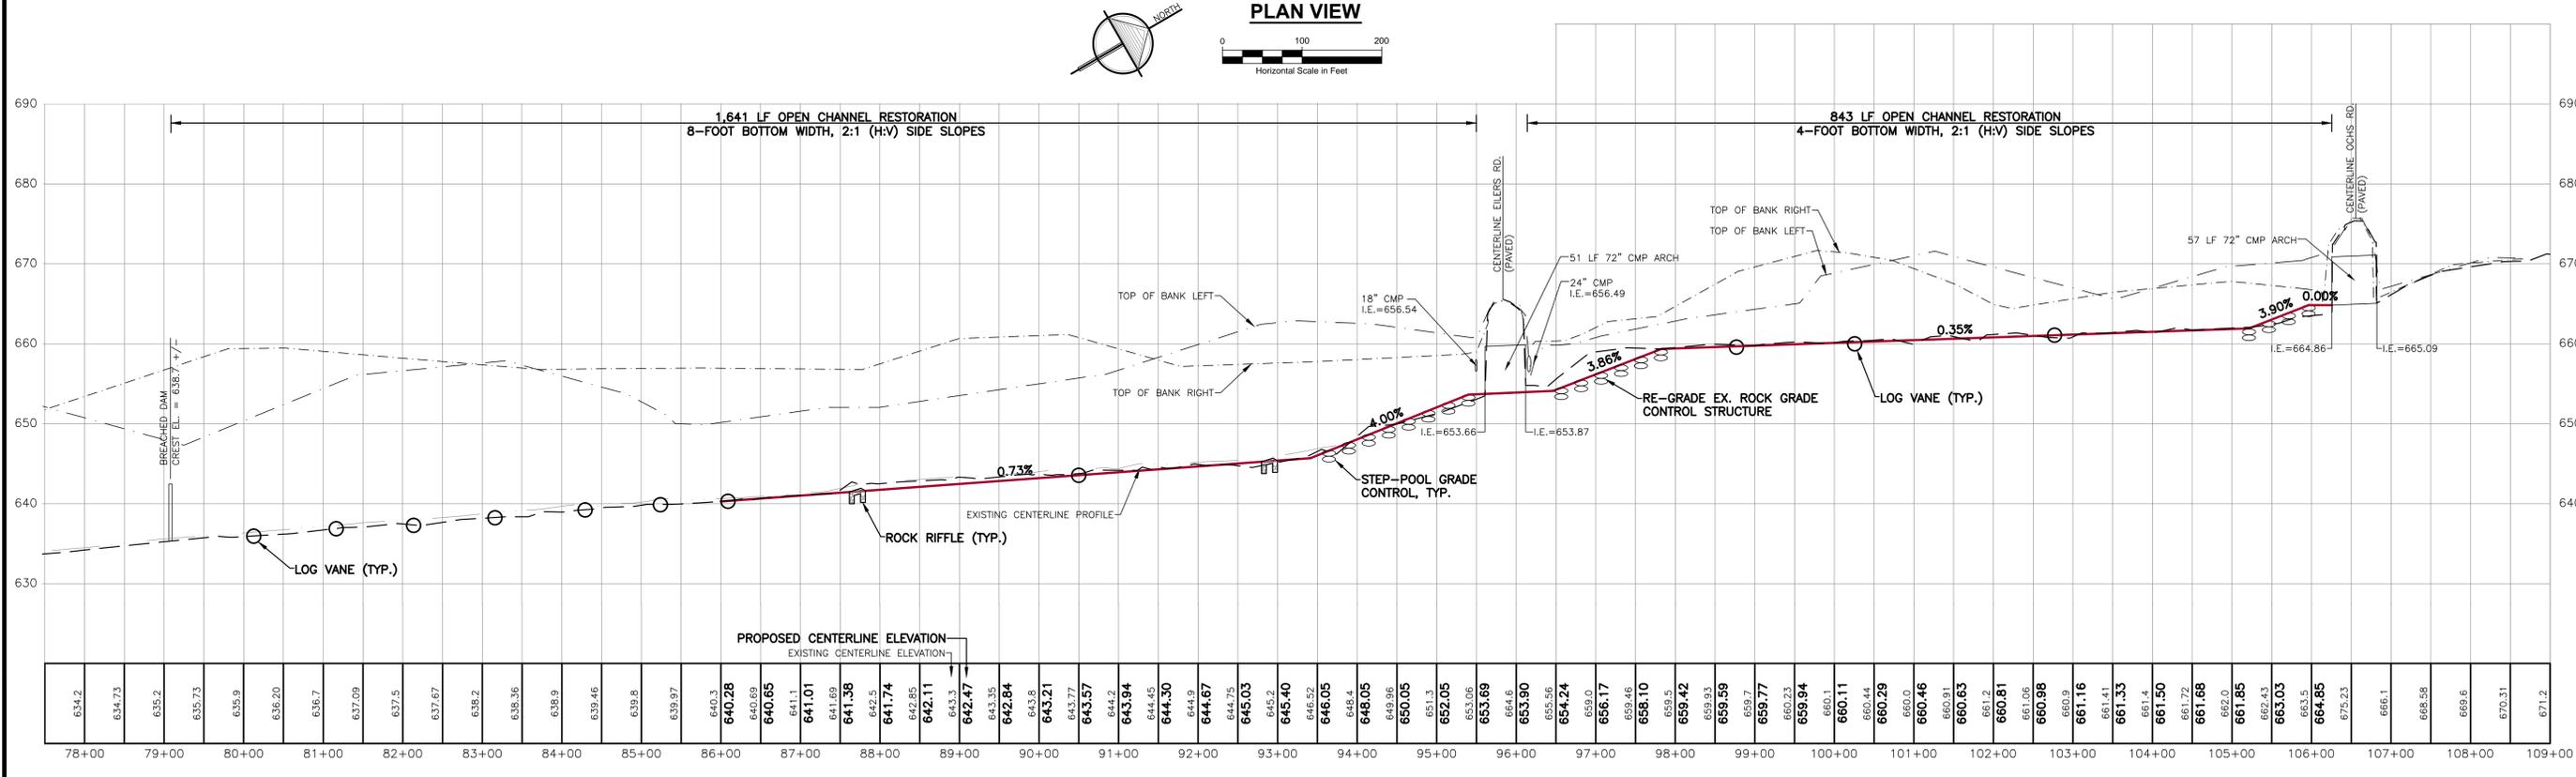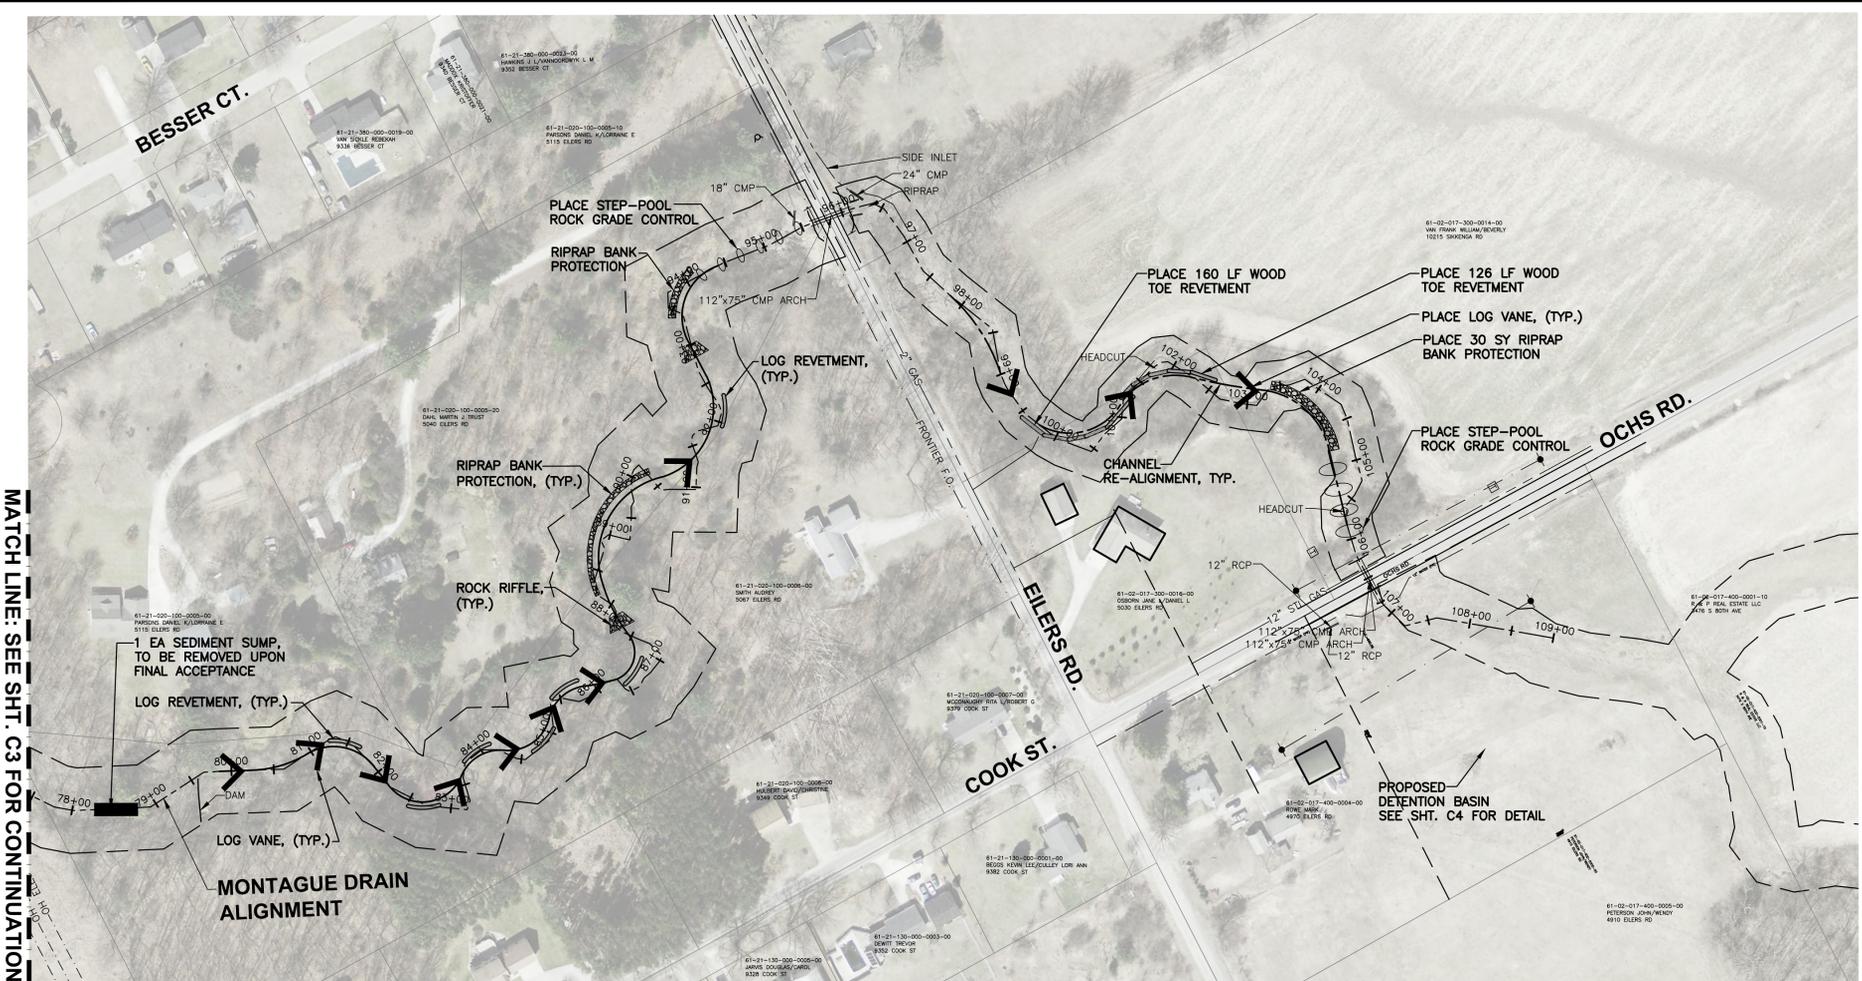

**CENTERLINE PROFILE**  
 SCALE: HORIZONTAL: 1" = 100'  
 VERTICAL: 1" = 10'

3 WORKING DAYS  
**BEFORE YOU DIG**  
 CALL MISS DIG  
 1-800-482-7171

ALL UTILITIES AS SHOWN ARE APPROXIMATE LOCATIONS DERIVED FROM ACTUAL MEASUREMENTS AND AVAILABLE RECORDS. THEY SHOULD NOT BE INTERPRETED TO BE EXACT LOCATION NOR SHOULD IT BE ASSUMED THAT THEY ARE THE ONLY UTILITIES IN THE AREA.

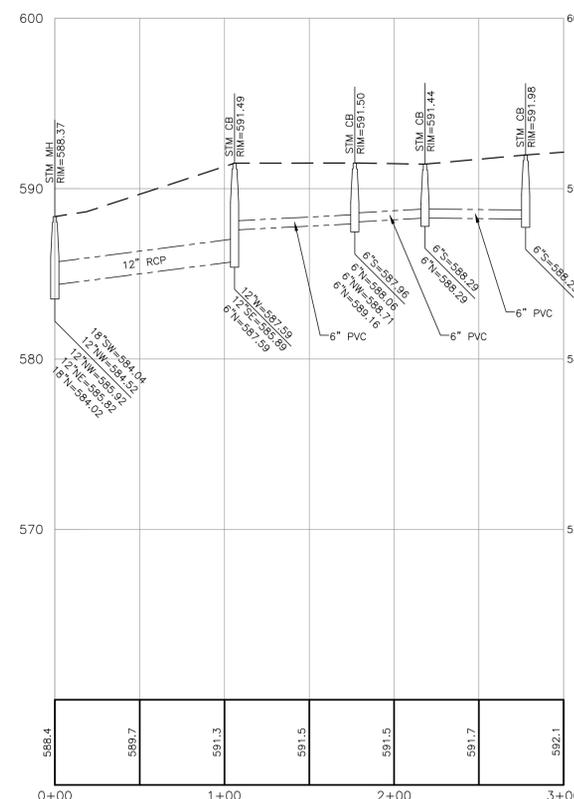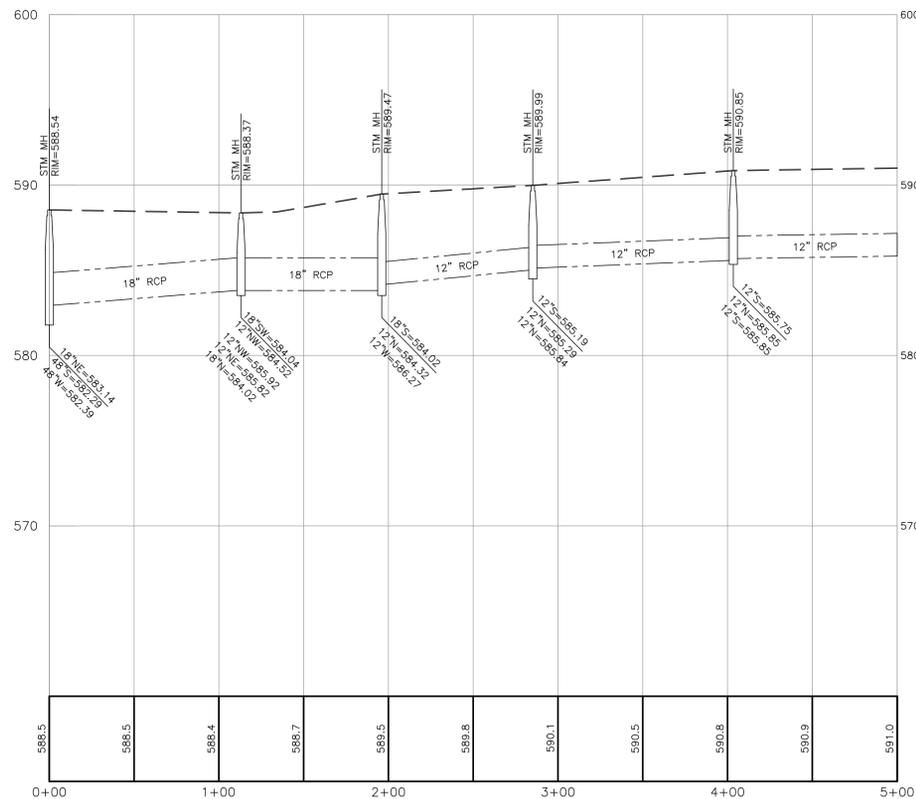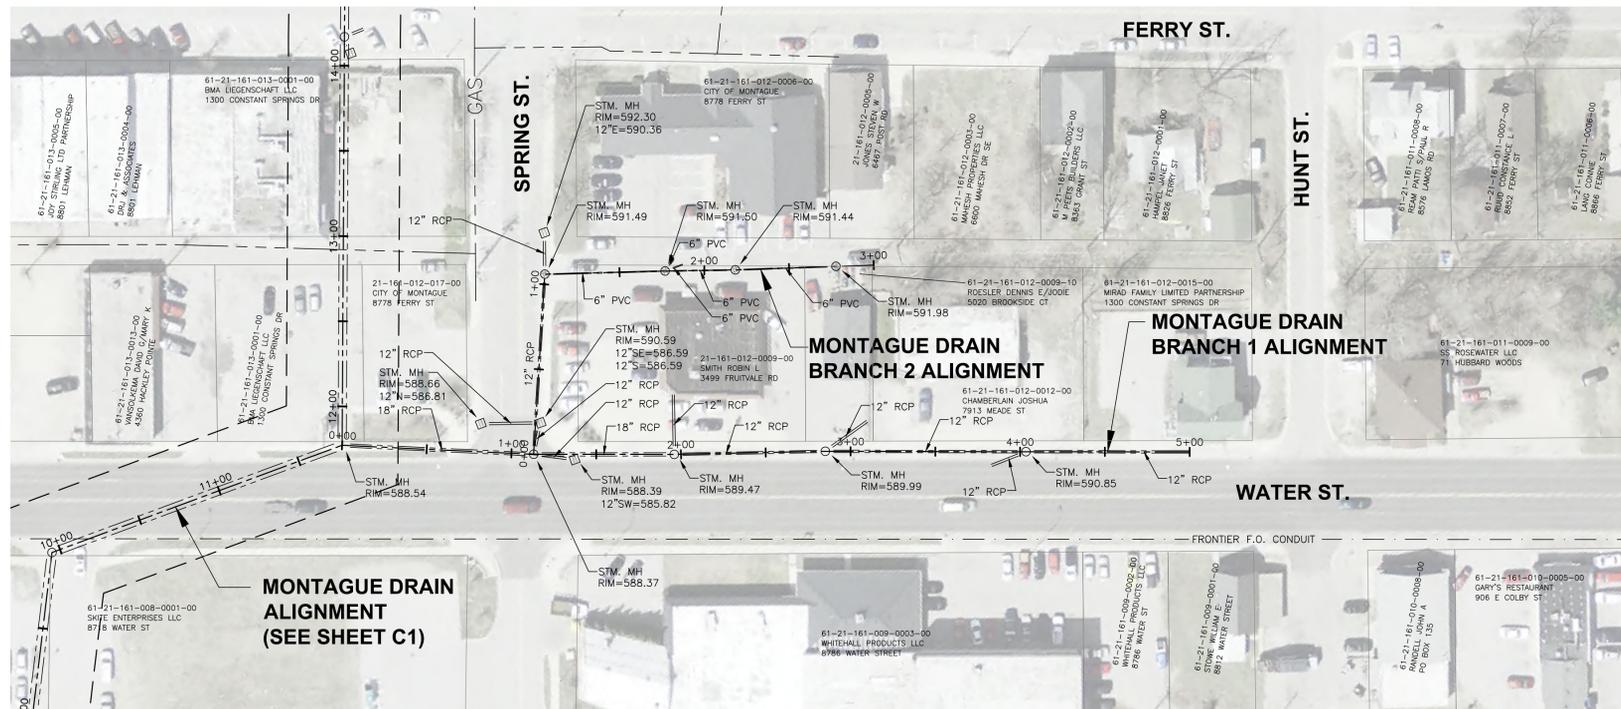

**CENTERLINE PROFILE**  
SCALE: HORIZONTAL: 1" = 50'  
VERTICAL: 1" = 5'



**3 WORKING DAYS  
BEFORE YOU DIG  
CALL MISS DIG  
1-800-482-7171**

ALL UTILITIES AS SHOWN ARE APPROXIMATE LOCATIONS DERIVED FROM ACTUAL MEASUREMENTS AND AVAILABLE RECORDS. THEY SHOULD NOT BE INTERPRETED TO BE EXACT LOCATION NOR SHOULD IT BE ASSUMED THAT THEY ARE THE ONLY UTILITIES IN THE AREA.

NO.	ISSUED FOR	DATE
1.	PRELIMINARY REVIEW	11/2017
2.	OWNER REVIEW - 50% DESIGN	02/2018
3.	OWNER REVIEW - 75% DESIGN	08/2018

**MUSKEGON COUNTY DRAIN COMMISSION**  
MUSKEGON, MICHIGAN

**MONTAGUE DRAIN**  
CITY OF MONTAGUE & MONTAGUE TOWNSHIP, MUSKEGON COUNTY, MICHIGAN

DATE	PROJECT
11/2017	MONTAGUE DRAIN
11/2017	MONTAGUE DRAIN
2/2018	MONTAGUE DRAIN

**PLAN & PROFILE**  
BRANCH 1 0+00 - 5+00  
BRANCH 2 0+00 - 3+00

SHEET NUMBER  
**C5**

